


IF IN DOUBT - ASK

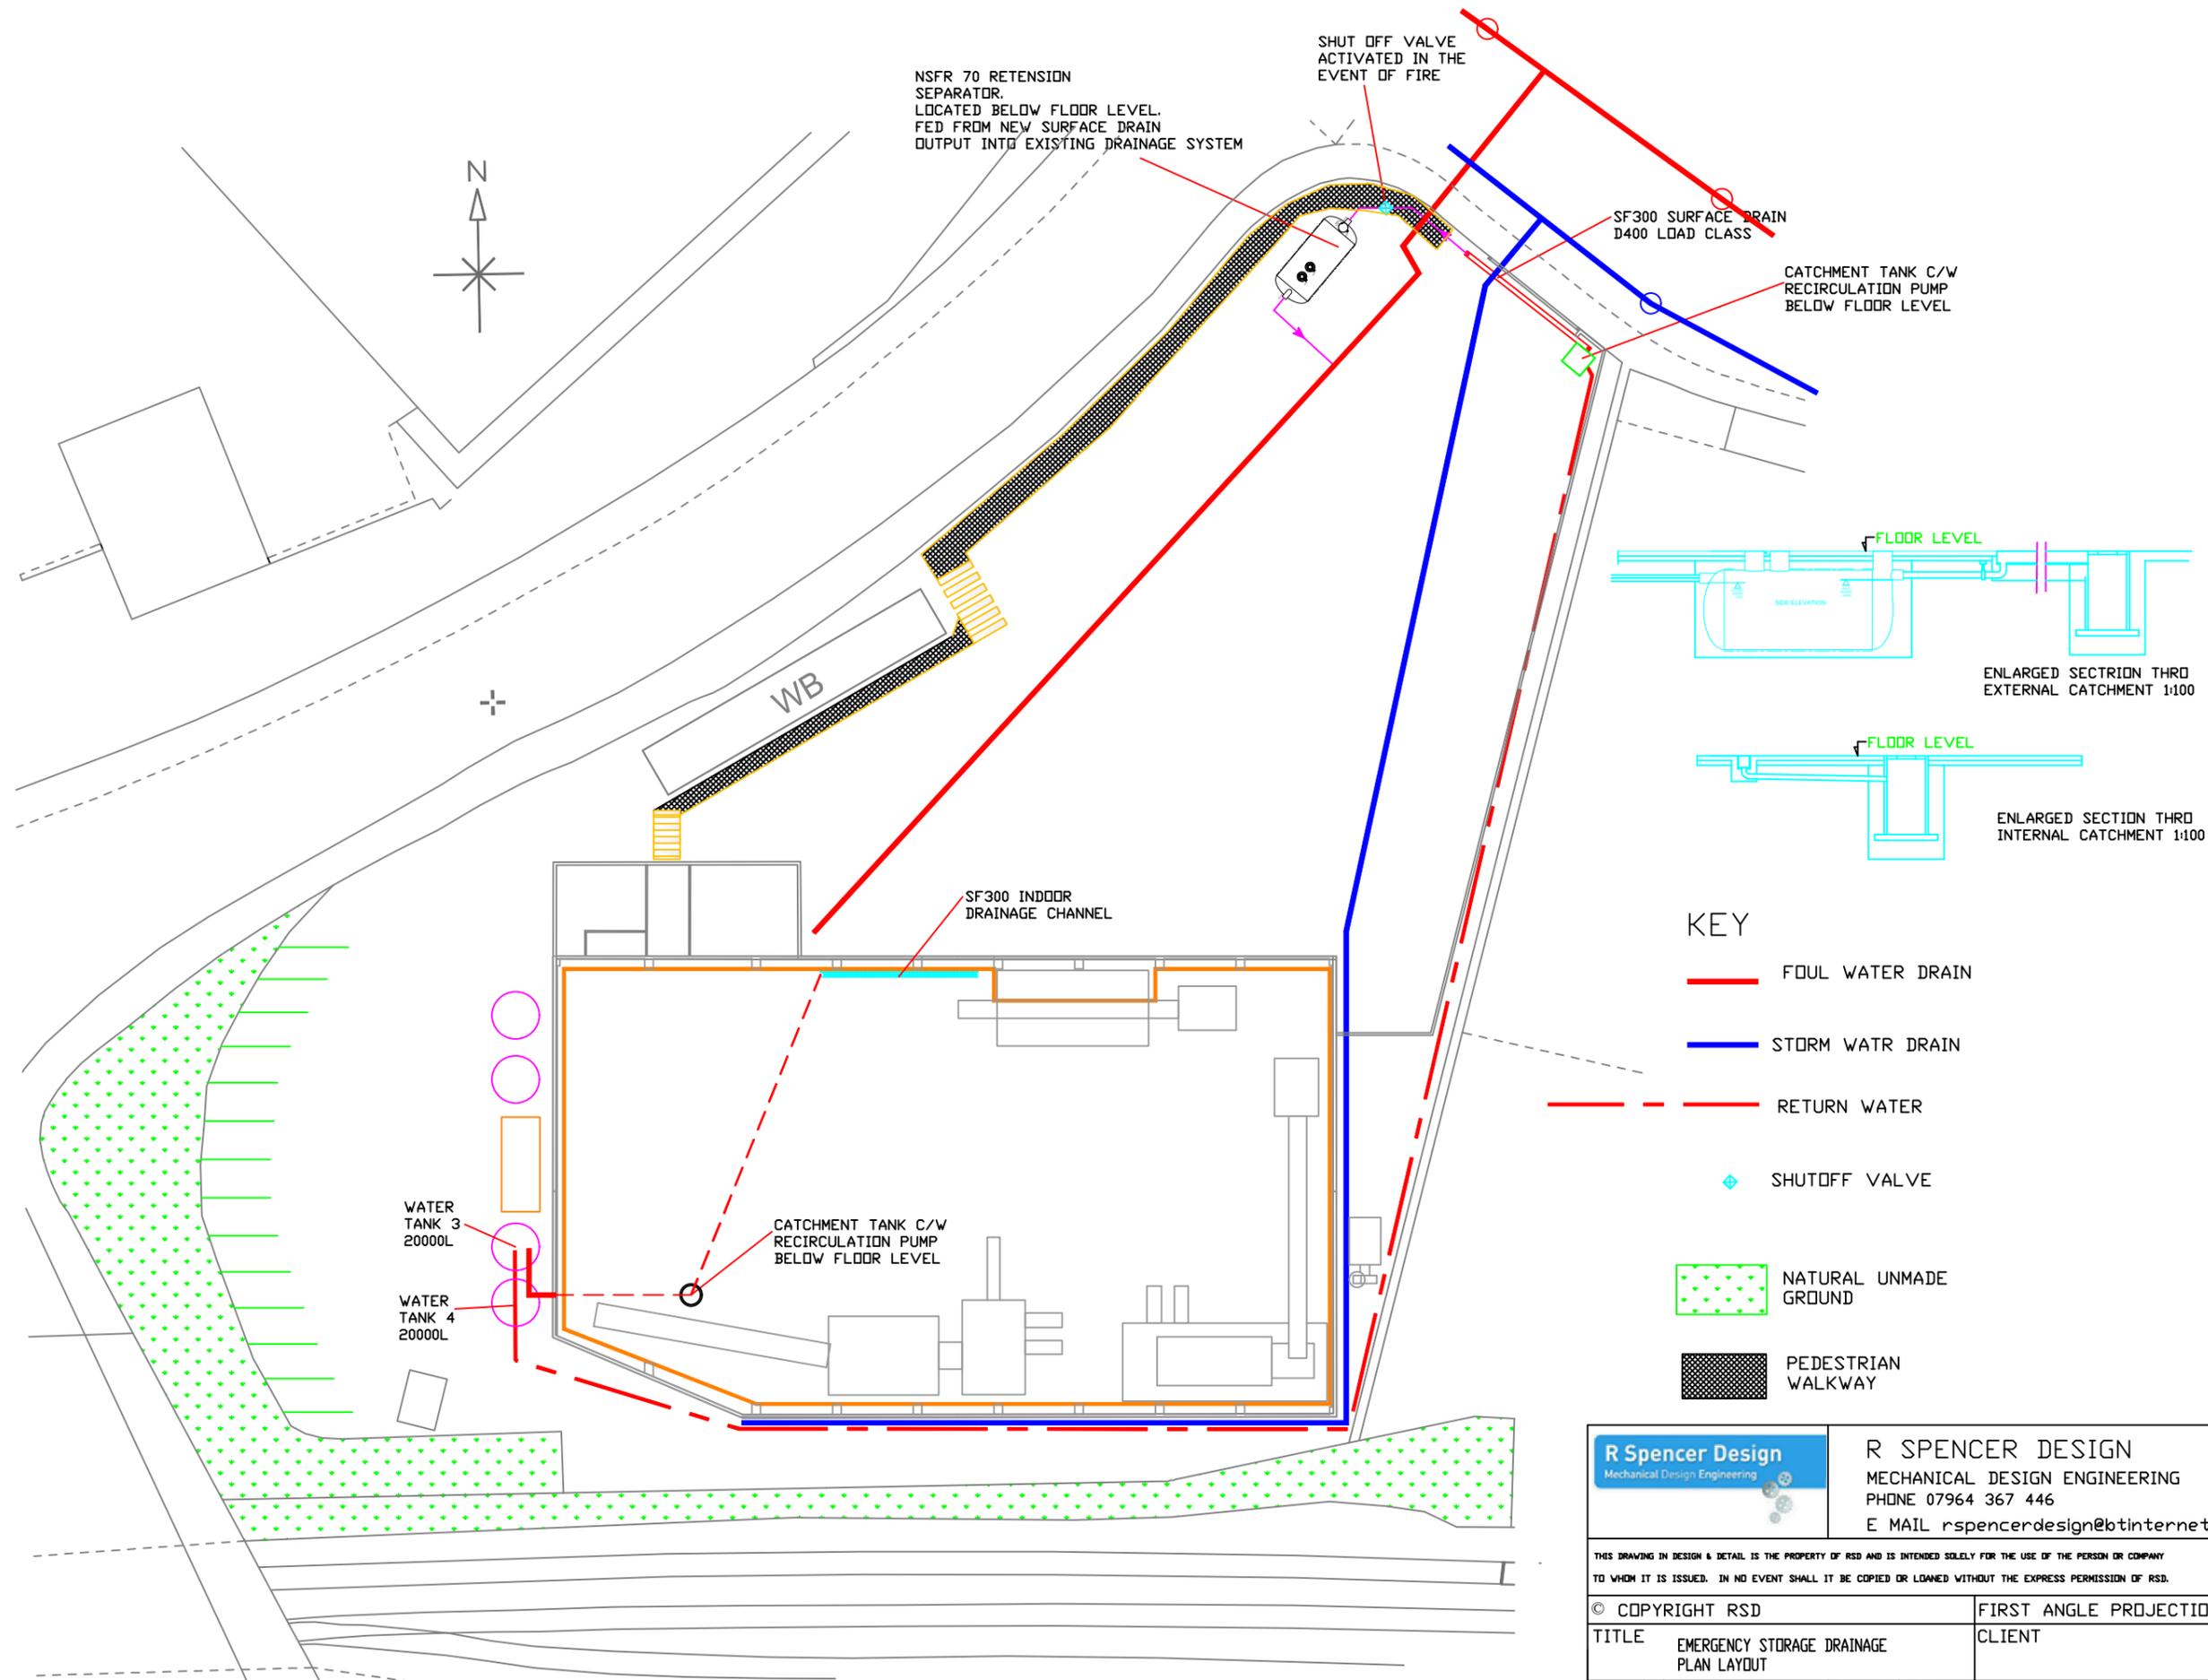

NSFR 70 RETENSION SEPARATOR. LOCATED BELOW FLOOR LEVEL. FED FROM NEW SURFACE DRAIN OUTPUT INTO EXISTING DRAINAGE SYSTEM

SHUT OFF VALVE ACTIVATED IN THE EVENT OF FIRE

SF300 SURFACE DRAIN D400 LOAD CLASS

CATCHMENT TANK C/W RECIRCULATION PUMP BELOW FLOOR LEVEL


WB

SF300 INDOOR DRAINAGE CHANNEL

WATER TANK 3 20000L

WATER TANK 4 20000L

CATCHMENT TANK C/W RECIRCULATION PUMP BELOW FLOOR LEVEL

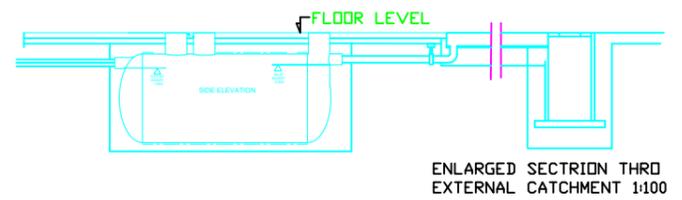

KEY

- FOUL WATER DRAIN
- STORM WATR DRAIN
- - - RETURN WATER
- ◆ SHUTOFF VALVE
- NATURAL UNMADE GROUND
- ▨ PEDESTRIAN WALKWAY

R Spencer Design Mechanical Design Engineering		R SPENCER DESIGN MECHANICAL DESIGN ENGINEERING PHONE 07964 367 446 E MAIL rspencerdesign@btinternet.com	
<small>THIS DRAWING IN DESIGN & DETAIL IS THE PROPERTY OF RSD AND IS INTENDED SOLELY FOR THE USE OF THE PERSON OR COMPANY TO WHOM IT IS ISSUED. IN NO EVENT SHALL IT BE COPIED OR LOANED WITHOUT THE EXPRESS PERMISSION OF RSD.</small>			
© COPYRIGHT RSD		FIRST ANGLE PROJECTION	
TITLE EMERGENCY STORAGE DRAINAGE PLAN LAYOUT		CLIENT	
DRAWN R SPENCER	SCALE 1:200 (A1)	DRG No PV 4	
DATE			